



**REVISED**

Liberty Utilities (EnergyNorth Natural Gas) Corp. d/b/a Liberty Utilities

DG 14-091

Liberty Utilities/iNATGAS Special Contract and Lease Agreement

Staff Data Requests – Set 4, Part 2

Date Request Received: 5/30/14  
Request No. Staff 4-3

Date of Response: 6/6/14  
Respondent: William J. Clark


---

**REQUEST:**

Re. the response to Attachment Staff 3-2, pages 1 through 4. Please provide revised copies of the site and equipment plan drawings that show the boundaries for the vapor dispersion zone and the thermal radiation zone of the existing LNG facility in relation to the proposed CNG facility.

**RESPONSE:**

Please see Attachment Staff 4-3 which includes boundaries for the vapor dispersion zone of the existing LNG facility in relation to the proposed CNG facility.

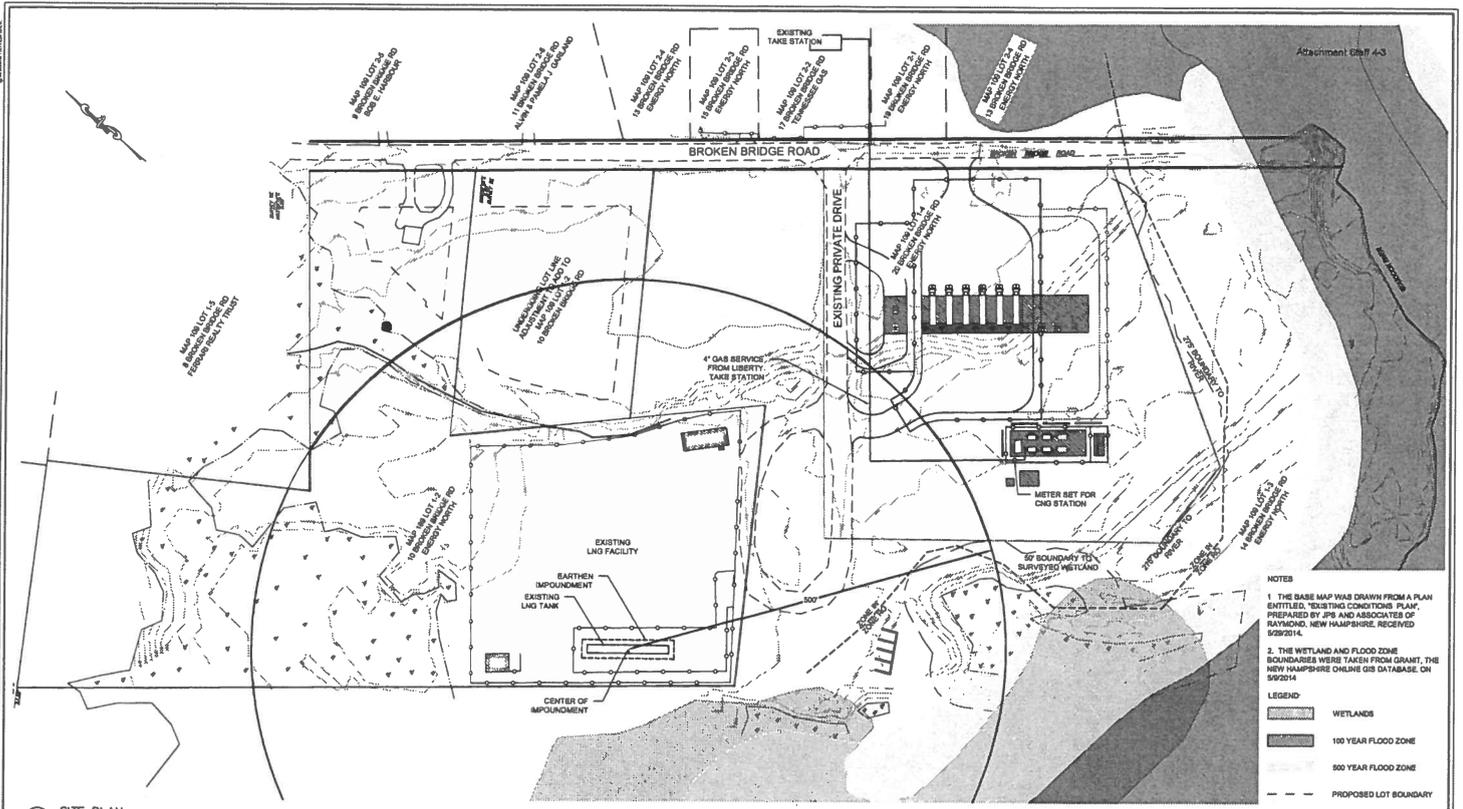

**NOTES**

1. THE BASE MAP WAS DRAWN FROM A PLAN ENTITLED "EXISTING CONDITIONS PLAN," PREPARED BY JPI AND ASSOCIATES OF RAYMOND, NEW HAMPSHIRE, RECEIVED 02/26/14.
2. THE WETLAND AND FLOOD ZONE BOUNDARIES WERE TAKEN FROM GRANT, THE NEW HAMPSHIRE ONLINE GIS DATABASE, ON 02/26/14.

**LEGEND**

- WETLANDS
- 100 YEAR FLOOD ZONE
- 500 YEAR FLOOD ZONE
- PROPOSED LOT BOUNDARY

**GRAPHICAL SCALE**

0' 20' 40' 60' 80' 100'

A1 SITE PLAN  
SCALE: 1" = 60'

		<b>DRAFT</b>	<table border="1"> <tr> <td>NO.</td> <td>DATE</td> <td>DESCRIPTION</td> <td>BY</td> </tr> <tr> <td>1</td> <td>6/2/2014</td> <td>MOVED COMPRESSORS PER PUC REQUEST</td> <td>ABW</td> </tr> <tr> <td>0</td> <td>02/1/2014</td> <td>PRELIMINARY ISSUE</td> <td>DRH</td> </tr> </table>	NO.	DATE	DESCRIPTION	BY	1	6/2/2014	MOVED COMPRESSORS PER PUC REQUEST	ABW	0	02/1/2014	PRELIMINARY ISSUE	DRH	<table border="1"> <tr> <td>DRAWN BY</td> <td>ABW</td> </tr> <tr> <td>DESIGNED BY</td> <td>DRH</td> </tr> <tr> <td>REVIEWED BY</td> <td>MAN</td> </tr> <tr> <td>PROJECT MGR.</td> <td>JAF</td> </tr> <tr> <td>PI</td> <td>MAN</td> </tr> <tr> <td>DATE</td> <td>JUNE 2014</td> </tr> </table>	DRAWN BY	ABW	DESIGNED BY	DRH	REVIEWED BY	MAN	PROJECT MGR.	JAF	PI	MAN	DATE	JUNE 2014	<table border="1"> <tr> <td colspan="2"> <b>BROKEN BRIDGE - CNG FACILITY DESIGN</b>  <b>LIBERTY UTILITIES</b>          CONCORD, NH       </td> <td>         PROJECT NUMBER:  <b>3872.01</b> </td> </tr> <tr> <td colspan="2"> <b>SITE PLAN</b> </td> <td>         SHEET NUMBER:  <b>M-101-B</b> </td> </tr> </table>	<b>BROKEN BRIDGE - CNG FACILITY DESIGN</b> <b>LIBERTY UTILITIES</b> CONCORD, NH		PROJECT NUMBER: <b>3872.01</b>	<b>SITE PLAN</b>		SHEET NUMBER: <b>M-101-B</b>
			NO.	DATE	DESCRIPTION	BY																													
1	6/2/2014	MOVED COMPRESSORS PER PUC REQUEST	ABW																																
0	02/1/2014	PRELIMINARY ISSUE	DRH																																
DRAWN BY	ABW																																		
DESIGNED BY	DRH																																		
REVIEWED BY	MAN																																		
PROJECT MGR.	JAF																																		
PI	MAN																																		
DATE	JUNE 2014																																		
<b>BROKEN BRIDGE - CNG FACILITY DESIGN</b> <b>LIBERTY UTILITIES</b> CONCORD, NH		PROJECT NUMBER: <b>3872.01</b>																																	
<b>SITE PLAN</b>		SHEET NUMBER: <b>M-101-B</b>																																	